



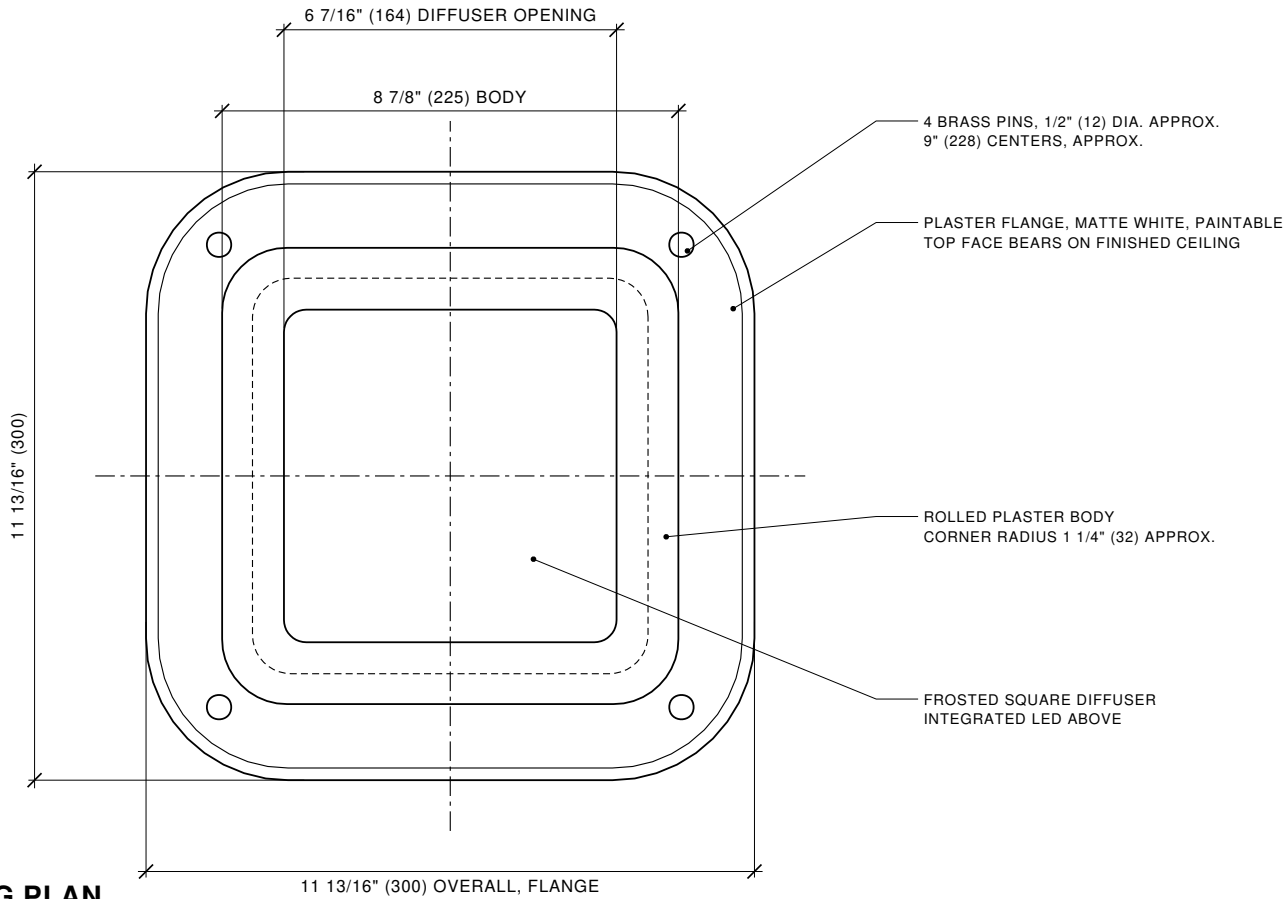

1 REFLECTED CEILING PLAN

SCALE: NTS

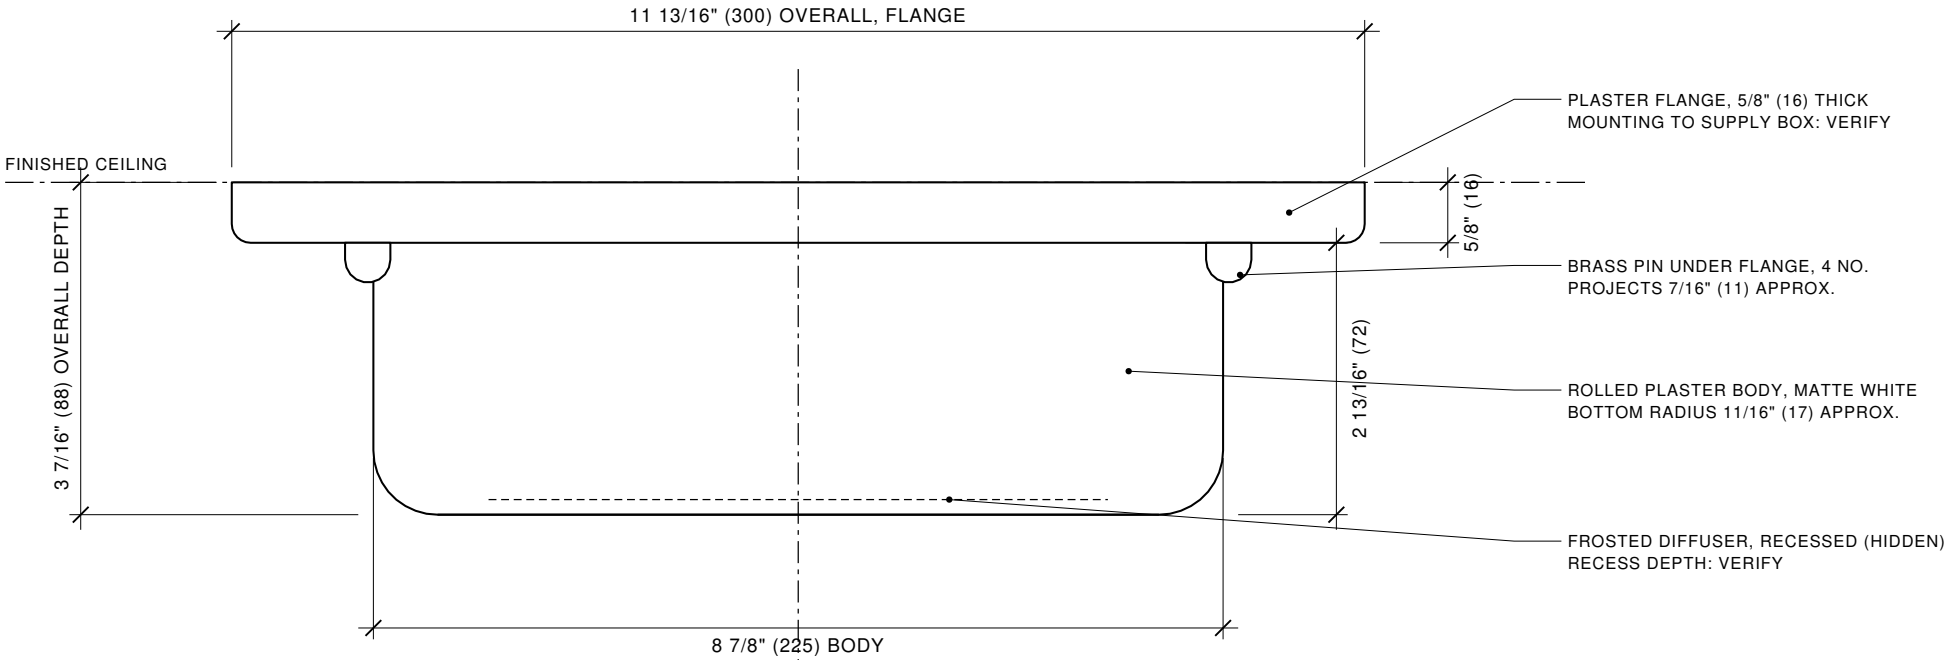

2 ELEVATION

SCALE: NTS

DIMENSIONS, INCHES (MM)

OVERALL, FLANGE	11 13/16" (300) square, rounded corners
OVERALL DEPTH	3 7/16" (88), finished ceiling to bottom
FLANGE	5/8" (16) thick
BODY	8 7/8" (225) square, 2 13/16" (72) below flange
DIFFUSER OPENING	6 7/16" (164) square
PINS	4 no., 1/2" (12) dia., 9" (228) centers, approx.
RADII	Flange 2 3/4" (70), body 1 1/4" (32), approx.

SPECIFICATION

TYPE	Plaster flush mount, ceiling or wall
BODY	Plaster, matte white, paintable
PINS	Brass, at the flange corners
DIFFUSER	Frosted, square, recessed
LIGHT SOURCE	Integrated LED, 17W to 18W max: VERIFY
COLOUR TEMP.	3000K: VERIFY (5 CCT also stated)
DIMMING	TRIAC dimmable. No remote
WIRING	USA standard. Not UL or CSA listed as standard

NOTES

- The top face of the flange sits on the finished ceiling.
- Projects 3 7/16" (88) below the finished ceiling.
- Dimensions marked APPROX. are scaled, not dimensioned.
- Plaster is a natural material. Each piece varies slightly.

INSTALLATION

- 1 Fix the mounting plate to the supply box: VERIFY.
- 2 Connect the supply to the integrated LED driver.
- 3 Bring the flange tight to the finished ceiling and fix.
- 4 Check that the diffuser is seated before switching on.

VERIFY BEFORE ORDERING

- Wattage, lumen output and colour temperature
- Mounting plate, fixing method and driver location
- Diffuser recess depth, pin size and corner radii
- Weight, rating for location, and UL or CSA listing

DIMENSIONS IN INCHES (MM). DO NOT SCALE.

© 2026 Brendan Tadler. All rights reserved.
Design and drawings may not be reproduced without permission.

MARSHMALLOW FLUSH MOUNT

Brendan Tadler